


LEGEND:

EXISTING	PROPOSED
GUARD HOUSE	FY 2019
ADMINISTRATION BUILDING	SITE DEVELOPMENT, PHASE 5
ACADEMIC BLDG. 1	COMPLETION OF NETWORK INFRASTRUCTURE AND COMMUNICATION SYSTEM
ACADEMIC BLDG. 2	MOTORPOOL/PARKING
PAVILLION	GREENHOUSE
PENTAGON	PROPERTY BLDG.
MAKESHIFT GARAGE	MATERIALS RECOVERY FACILITY
CANTEEN	UPGRADING OF ELECTRICAL POWER DISTRIBUTION SYSTEM AND EMERGENCY POWER SYSTEM
AUDITORIUM	FY 2020
BOYS' DORM.	INSTALLATION OF SOLAR PANELS FOR DORMITORIES
GIRLS' DORM.	SPRINKLER SYSTEM FOR ACADEMIC BUILDINGS AND SCIENCE LAB. AND TECH. BLDG.
MULTI-PURPOSE GYM	REPAIR OF ADMINISTRATIVE BUILDING
MAKESHIFT CLASSROOM 1	FY 2021
MAKESHIFT CLASSROOM 2	CONSTRUCTION OF RESOURCE LEARNING CENTER
POWER HOUSE	FABLAB WITH EQUIPMENT
SCIE. LAB. & TECH. BLDG.	PLANETARIUM
WATER SYSTEM W/ CISTERN TANK	REPAIR OF DORMITORY BLDG. II
	UPGRADING OF AUDITORIUM
ONGOING	
ACADEMIC BLDG. III	
SEWAGE TREATMENT FACILITY	
DORMITORY BLDG. III	
SITE DEVELOPMENT, PHASE 4	
PERIMETER LIGHTINGS	
SERVICE ROAD	
COVERED WALK	
GROUTED RIPRAP	
OUTDOOR STUDY AREA	

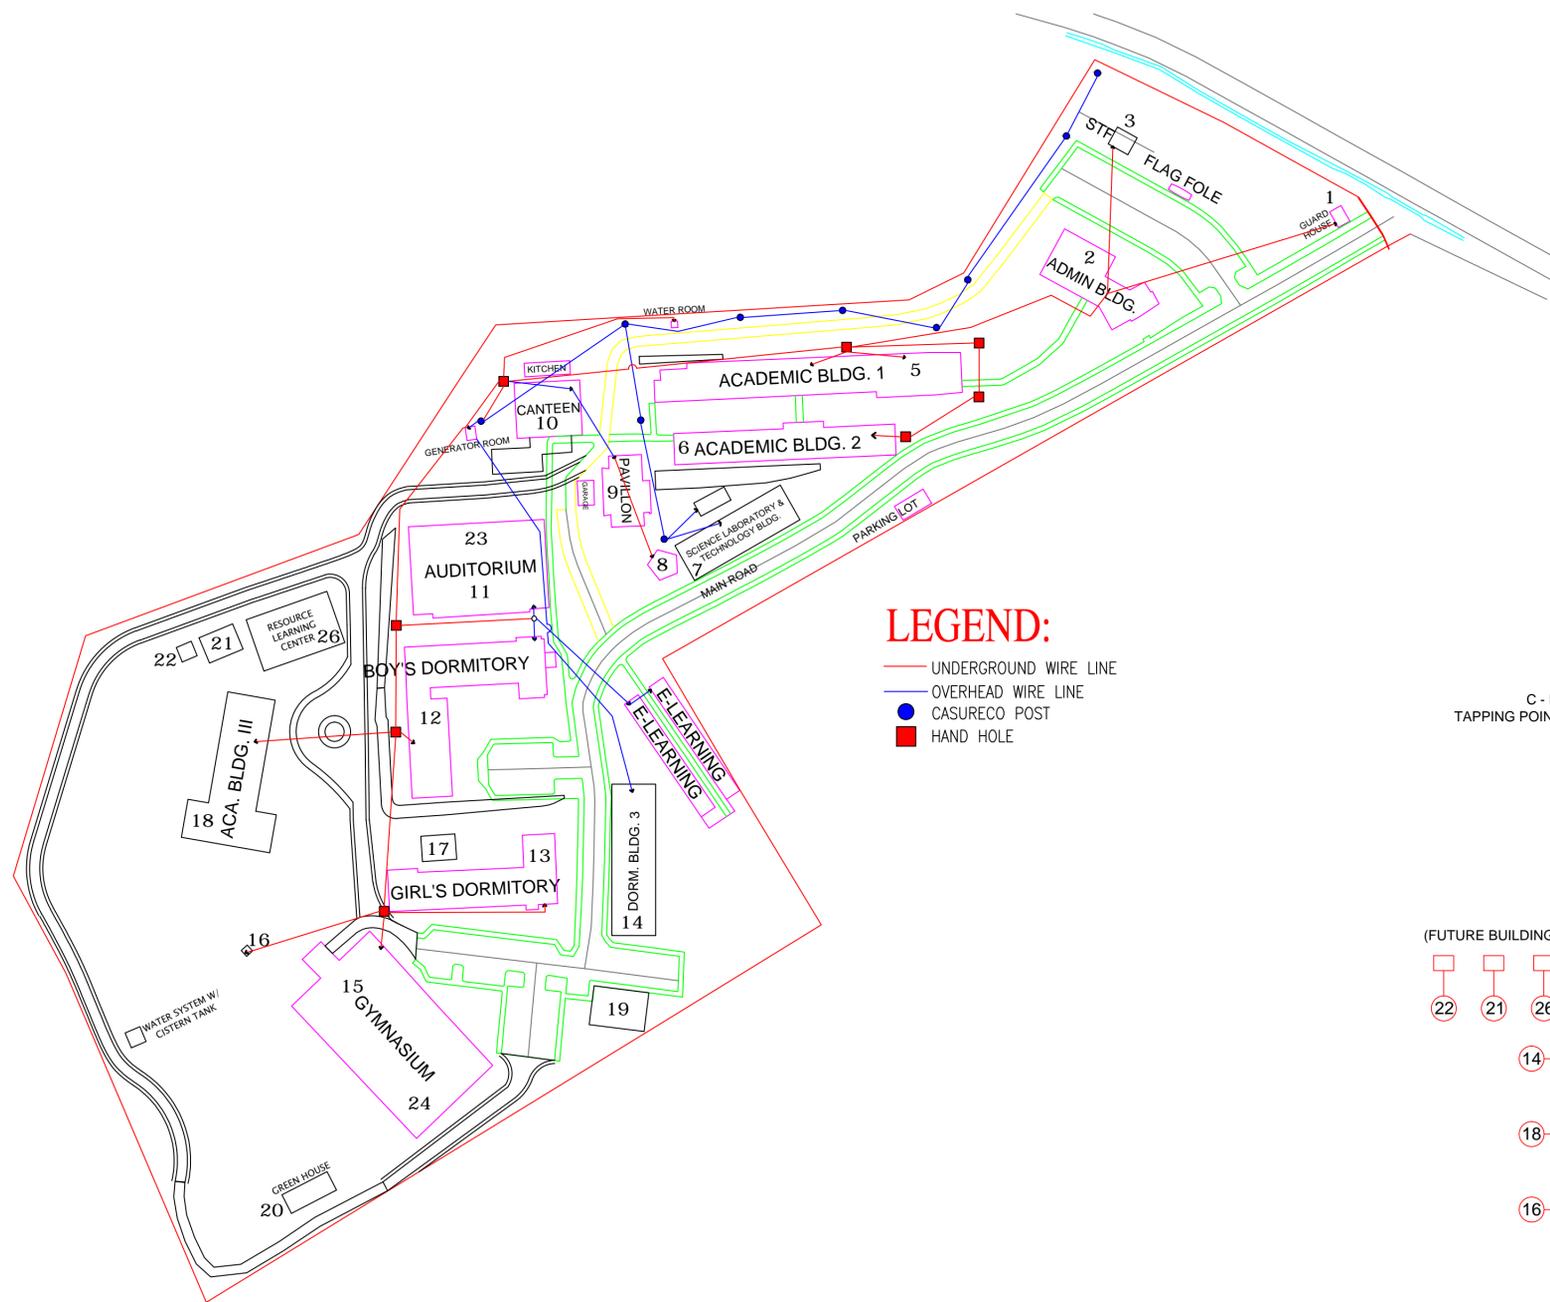


LEGEND:

- UNDERGROUND WIRE LINE
- OVERHEAD WIRE LINE
- CASURECO POST
- HAND HOLE

SITE DEVELOPMENT PLAN

NTS

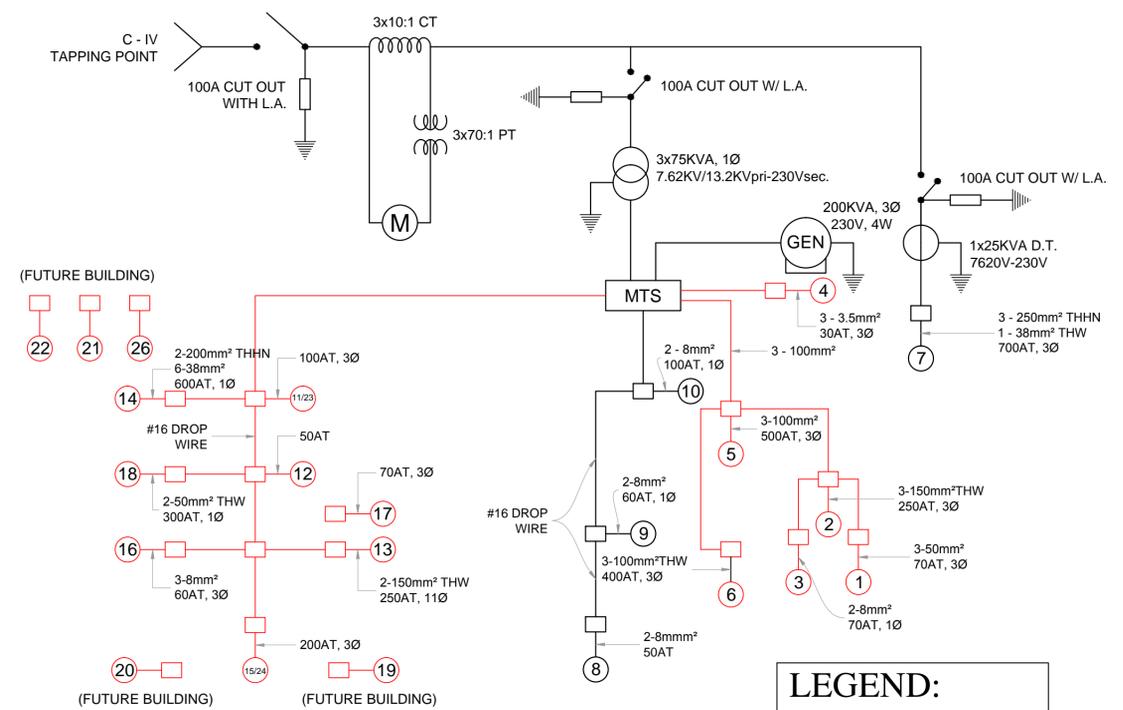

LEGEND:

- ARIAL INSTALLATION
- UNDERGROUND

SINGLE LINE ELECTRICAL DISTRIBUTION SYSTEM (PRIMARY & SECONDARY LINE)

 <p>PSHS - BRC Brgy. Tagongtong, Goa, Camarines Sur</p>	PROJECT TITLE & LOCATION	ARIEL O. SORIANO PROFESSIONAL ELECTRICAL ENGINEER	R.A. 9266	REVIEWED BY :	RECOMMENDING APPROVAL :	APPROVED :	SHEET No.
	EXISTING SINGLE LINE DIAGRAM (EXTENSION) OF PRIMARY & SECONDARY DISTRIBUTION LINE & SITE DEVELOPMENT PLAN	PTR No. 3 6 2 2 TIN : 901-370-573 PTR No. 8952673 DATE : 1-5-2018 PLACE : IRIGA CITY	THIS DRAWINGS, AS INSTRUMENT OF SERVICE, IS THE PROPERTY OF MARUYO C. AYOLE & ASSOCIATES, REGISTERED ARCHITECT AND AS SUCH MUST NOT BE REPRODUCED OR COPIED IN PART OR IN WHOLE WITHOUT THEIR PERMISSION. ALL DRAWINGS ARE TO BE RETURNED WHEN NO LONGER IN USE.	MARCO M. DESPI	MARIA CECILIA A. GONZAGA	ELSIE G. FERRER	E-1
				INFORMATION SYSTEM ANALIST	SUPERVISING ADMINISTRATIVE OFFICER	DIRECTOR	