


1 CROSS SECTION
A-7 SCALE 1:100M

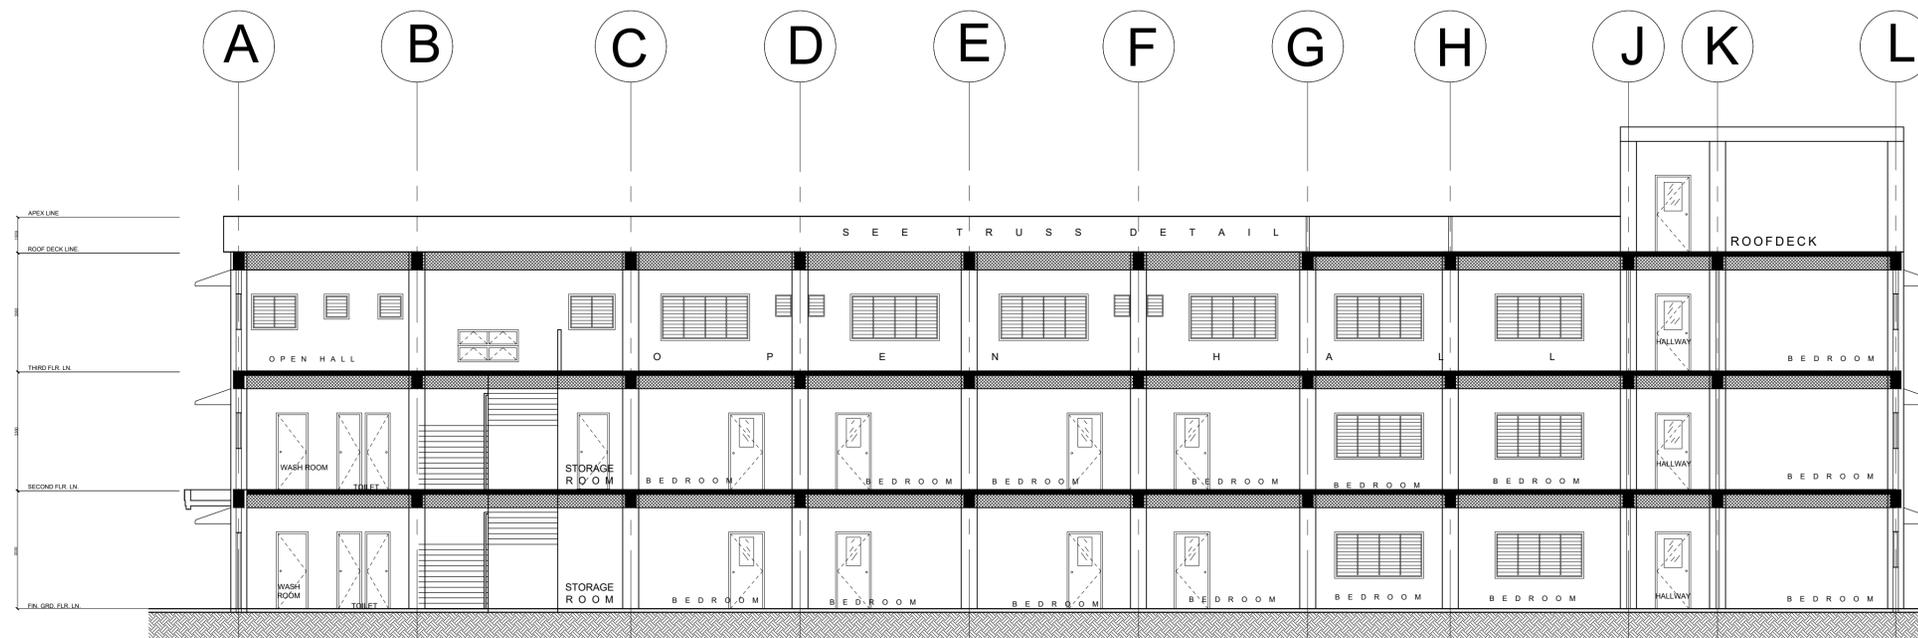

1 LONGITUDINAL SECTION
A-7 SCALE 1:100M

 Asyana CONSTRUCTION & CONSULTANCY Contact Number 0956-768-2678 ferbal_1@yahoo.com.ph	ARCHITECT	SUBMITTED BY:	PROJECT TITLE	SHEET CONTENTS	OWNER	RECOMMENDING APPROVAL:	APPROVED BY:	<small>R.A. 9266 – THIS DRAWING IS AN INSTRUMENT OF SERVICE AND PROPERTY OF ASYANA CONSTRUCTION & CONSULTANCY. UNAUTHORIZED REPRODUCTION IN PART OR IN WHOLE IS PROHIBITED WITHOUT WRITTEN CONSENT.</small>	SCALE	AS SHOWN	PROJECT I.D. NO.		
	ARCHITECT	ASYANA CONSTRUCTION CONSULTANCY	REHABILITATION OF SCHOOL BUILDINGS ACADEMIC BUILDING I, II AND DORMITORY BUILDING (BOY'S DORM)	(GROUND FLOOR) LIGHTING LAYOUT	 PHILIPPINE SCIENCE HIGH SCHOOL BICOL REGION CAMPUS DEPARTMENT OF SCIENCE AND TECHNOLOGY	JAY P. BASSIG FAD CHIEF	LORVI B. PAGOROGON, RPAE, MHWQ DIRECTOR III		CADD	JP/DANIELLE	202 - -		
	PTR NO. :	REG. NO. :	PROPRIETRESS	LOCATION: TAGONGTONG, GOA, CAMARINES SUR						CHECKED	FLB	SHEET NO.	TOTAL SHTS.
	DATE :	T.I.N. :								FILE			